
# 1165R Massachusetts Avenue Ch. 40B ZBA Submission

### Section 3.2.5.7 Proposed Lighting and Photometric Analysis

Please see the enclosed Proposed Lighting and Photometric Analysis, prepared by Bohler Engineers, dated October 5, 2020 and REVISED May 26, 2021.

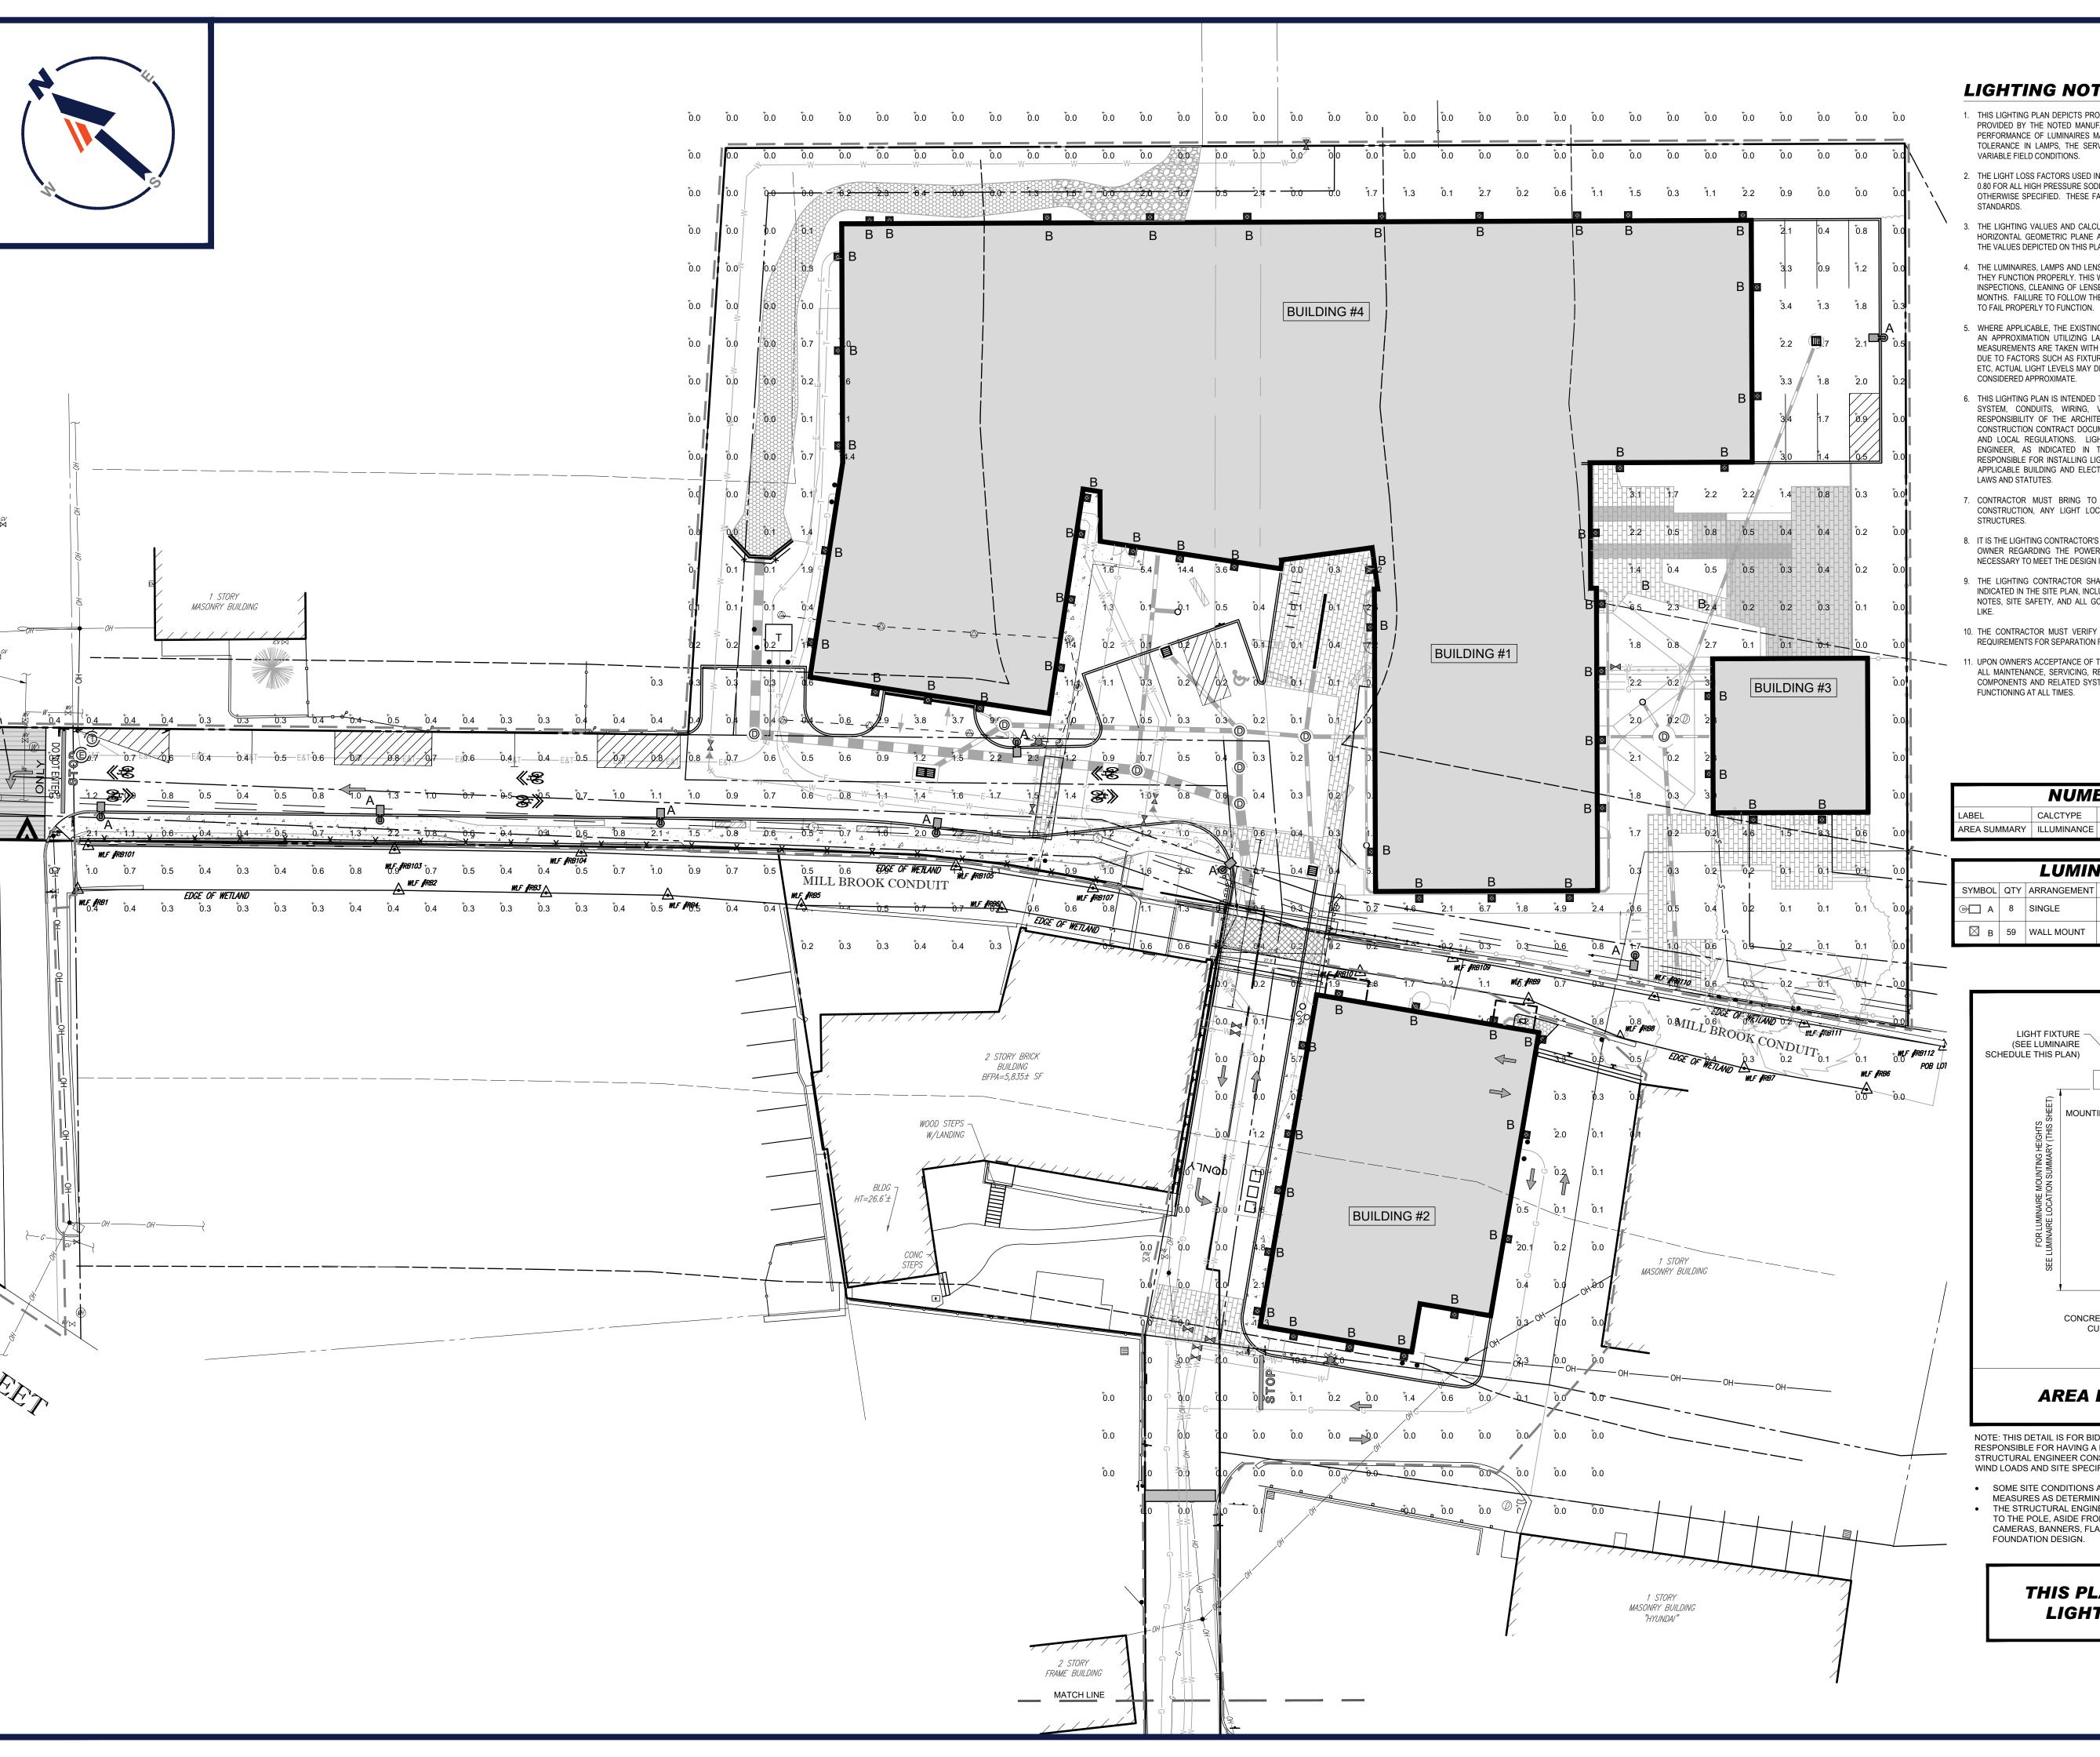

#### **LIGHTING NOTES**

- 1. THIS LIGHTING PLAN DEPICTS PROPOSED SUSTAINED ILLUMINATION LEVELS CALCULATED USING DATA PROVIDED BY THE NOTED MANUFACTURER(S). ACTUAL SUSTAINED SITE ILLUMINATION LEVELS AND PERFORMANCE OF LUMINAIRES MAY VARY DUE TO VARIATIONS IN WEATHER, ELECTRICAL VOLTAGE, TOLERANCE IN LAMPS, THE SERVICE LIFE OF EQUIPMENT AND LUMINAIRES AND OTHER RELATED VARIABLE FIELD CONDITIONS.
- 2. THE LIGHT LOSS FACTORS USED IN THESE LIGHTING CALCULATIONS ARE 0.90 FOR ALL LED LUMINAIRES, 0.80 FOR ALL HIGH PRESSURE SODIUM LUMINAIRES OR 0.72 FOR ALL METAL HALIDE LUMINAIRES UNLESS OTHERWISE SPECIFIED. THESE FACTORS ARE INDICATIVE OF TYPICAL LIGHTING INDUSTRY MODELING
- : THE LIGHTING VALUES AND CALCULATION POINTS DEPICTED ON THIS PLAN ARE ALL ANALYZED ON A HORIZONTAL GEOMETRIC PLANE AT ELEVATION ZERO (GROUND LEVEL) UNLESS OTHERWISE NOTED. THE VALUES DEPICTED ON THIS PLAN ARE IN FOOTCANDLES.
- 4. THE LUMINAIRES, LAMPS AND LENSES MUST BE REGULARLY INSPECTED/MAINTAINED TO ENSURE THAT THEY FUNCTION PROPERLY. THIS WORK SHOULD INCLUDE, BUT NOT BE LIMITED TO, FREQUENT VISUAL INSPECTIONS, CLEANING OF LENSES, AND RELAMPING (IF NECESSARY) AT LEAST ONCE EVERY SIX (6) MONTHS. FAILURE TO FOLLOW THE ABOVE STEPS COULD CAUSE THE LUMINAIRES, LAMPS AND LENSES
- 5. WHERE APPLICABLE, THE EXISTING CONDITION LIGHT LEVELS ILLUSTRATED ARE REPRESENTATIVE OF AN APPROXIMATION UTILIZING LABORATORY DATA FOR SIMILAR FIXTURES, UNLESS ACTUAL FIELD MEASUREMENTS ARE TAKEN WITH A LIGHT METER AND ARE, CONSEQUENTLY, APPROXIMATIONS ONLY. DUE TO FACTORS SUCH AS FIXTURE MAINTENANCE, EQUIPMENT TOLERANCES, WEATHER CONDITIONS, ETC, ACTUAL LIGHT LEVELS MAY DIFFER. EXISTING LIGHT LEVELS DEPICTED ON THIS PLAN SHOULD BE CONSIDERED APPROXIMATE.
- 6. THIS LIGHTING PLAN IS INTENDED TO SHOW THE LOCATIONS AND TYPE OF LUMINAIRES, ONLY. POWER SYSTEM, CONDUITS, WIRING, VOLTAGES AND OTHER ELECTRICAL COMPONENTS ARE THE RESPONSIBILITY OF THE ARCHITECT, MEP AND/OR LIGHTING CONTRACTOR, AS INDICATED IN THE CONSTRUCTION CONTRACT DOCUMENTS. THESE ITEMS MUST BE INSTALLED AS REQUIRED BY STATE AND LOCAL REGULATIONS. LIGHT POLE BASES ARE THE RESPONSIBILITY OF THE STRUCTURAL ENGINEER, AS INDICATED IN THE CONSTRUCTION CONTRACT DOCUMENTS. CONTRACTOR IS RESPONSIBLE FOR INSTALLING LIGHTING FIXTURES AND APPURTENANCES IN ACCORDANCE WITH ALL APPLICABLE BUILDING AND ELECTRICAL CODES AND ALL OTHER APPLICABLE RULES, REGULATIONS,
- 7. CONTRACTOR MUST BRING TO DESIGNER'S ATTENTION, PRIOR TO THE COMMENCEMENT OF CONSTRUCTION, ANY LIGHT LOCATIONS THAT CONFLICT WITH DRAINAGE, UTILITIES, OR OTHER
- 8. IT IS THE LIGHTING CONTRACTOR'S RESPONSIBILITY TO COORDINATE WITH THE PROJECT ARCHITECT OR OWNER REGARDING THE POWER SOURCE(S) FROM WITHIN THE BUILDING, AND TIMING DEVICES NECESSARY TO MEET THE DESIGN INTENT.
- 9. THE LIGHTING CONTRACTOR SHALL COMPLY WITH ALL APPLICABLE CONTRACTOR REQUIREMENTS INDICATED IN THE SITE PLAN, INCLUDING BUT NOT LIMITED TO, GENERAL NOTES, GRADING AND UTILITY NOTES, SITE SAFETY, AND ALL GOVERNMENTAL RULES, LAWS, ORDINANCES, REGULATIONS AND THE
- 10. THE CONTRACTOR MUST VERIFY THAT INSTALLATION OF LIGHTING FIXTURES COMPLIES WITH THE REQUIREMENTS FOR SEPARATION FROM OVERHEAD ELECTRICAL WIRES PER STATE REGULATIONS.
- . UPON OWNER'S ACCEPTANCE OF THE COMPLETED PROJECT, THE OWNER SHALL BE RESPONSIBLE FOR ALL MAINTENANCE, SERVICING, REPAIR AND INSPECTION OF THE LIGHTING SYSTEM AND ALL OF ITS COMPONENTS AND RELATED SYSTEMS, TO ENSURE ADEQUATE LIGHTING LEVELS ARE PRESENT AND

## NUMERIC SUMMARY

CALCTYPE UNITS AVG MAX MIN AVG/MIN MAX/MIN AREA SUMMARY | ILLUMINANCE | FC | 1.14 | 17.3 | 0.0 | 0.00 | 0.00

## LUMINAIRE SCHEDULE

SYMBOL QTY ARRANGEMENT LUMENS LLF 5067 0.90 STERNBERG LIGHTING LED AREA LIGHT MOUNTED @ 20'; DRAWN BY: CHECKED BY: DATE: CAD I.D.: B 59 WALL MOUNT 1128 0.90 LIGMAN LIGHTING MATRIX SURFACE 4 LED WALL LIGHT MOUNTED @ 12'; UMT-31426-M-W30

LIGHT FIXTURE -(SEE LUMINAIRE SCHEDULE THIS PLAN) MOUNTING ARM POLE ---- FOUNDATION (DESIGN BY

## AREA LIGHT DETAIL

NOTE: THIS DETAIL IS FOR BID AND BUDGETARY PURPOSES ONLY. CONTRACTOR SHALL BE RESPONSIBLE FOR HAVING A FOUNDATION DESIGN PREPARED BY A QUALIFIED STRUCTURAL ENGINEER CONSIDERING LIGHTING MANUFACTURER REQUIREMENTS, LOCAL WIND LOADS AND SITE SPECIFIC SOIL PARAMETERS.

 
 SOME SITE CONDITIONS AND/OR LOCATIONS MAY REQUIRE VIBRATION DAMPENING MEASURES AS DETERMINED BY A STRUCTURAL ENGINEER.

OTHERS-SEE NOTE

BELOW)

 THE STRUCTURAL ENGINEER SHALL BE NOTIFIED OF THE INTENT TO MOUNT ANYTHING TO THE POLE, ASIDE FROM THE LIGHT FIXTURES, INCLUDING BUT NOT LIMITED TO CAMERAS, BANNERS, FLAGS, SIGNAGE, ETC. AS IT WILL IMPACT THE POLE AND FOUNDATION DESIGN.

> THIS PLAN TO BE UTILIZED FOR LIGHTING PURPOSES ONLY



**REVISIONS** 

REV DATE COMMENT

		CHECKED BY
3/10/20	REVISED BUILDING 2 & GRADING	BPB
		JMJ
06/15/20	SITE PLAN & GRADING	AWP
		JMJ
07/15/20	CONSERVATION	AWP
	COMMISSION	JMJ
08/21/20	CONSTRUCTION	AWP
	PHASING	JMJ
10/05/20	ZBA SUBMITTAL	AWP
	PROGRESS SET	JMJ
04/01/21	ZBA COMMENT	AWP
	RESPONSE	RMM
04/13/21	UPDATED SIGNAGE	CFD
		RMM
05/13/21	WATER LINE AND SIGNAGE	AWP
		RMM
05/26/21	124 UNIT BUILDING	AWP
		RMM



**ALWAYS CALL 811** It's fast. It's free. It's the law.

PERMIT SET

THIS DRAWING IS INTENDED FOR MUNICIPAL AND/OR AGENCY REVIEW AND APPROVAL. IT IS NOT INTENDED AS A CONSTRUCTIC DOCUMENT UNLESS INDICATED OTHERWISE.

W191330-CVL-9

PROPOSED SITE **PLAN DOCUMENTS** 

1165R MASS MA PROPERTY LLC

**PROPOSED RESIDENTIAL DEVELOPMENT** 

1165R MASSACHUSETTS AVE. MIDDLESEX COUNTY TOWN OF ARLINGTON, MA

MAP #57, BLOCK #2, LOT #10B

AND PART OF LOT #15

**352 TURNPIKE ROAD SOUTHBOROUGH, MA 01772** Phone: (508) 480-9900 Fax: (508) 480-9080

www.BohlerEngineering.com

J.G. SWEILING

SHEET TITLE:

**LIGHTING** PLAN

C-701

**REVISION 9 - 05/26/21**